


NOTE: FALSE CEILING OF THE REACT ROOM SHALL BE PLACED AT 9'-0" FROM THE FLOOR OF THE ROOM.  
 FALSE CEILING OF THE OFFICE SPACES SHALL BE 8'-6" FROM THE FLOOR LEVEL OF THE ROOM.

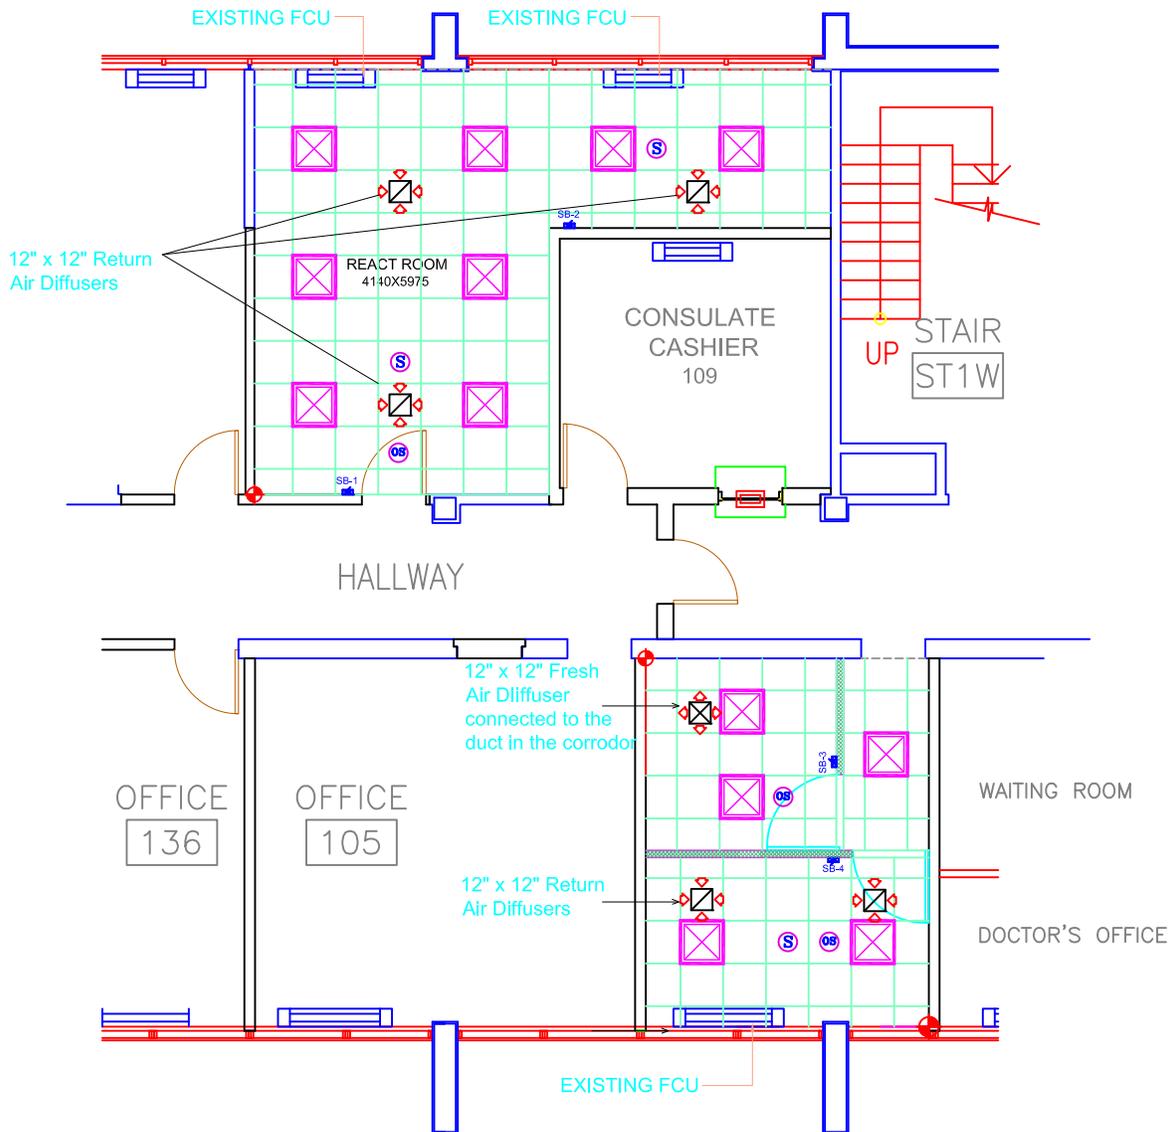

**PROPOSED FALSE CEILING PLAN**  
 SCALE 1:100

NOTE: SUPPLY OF CONDITIONED AIR IS FROM FCU'S IN THE PROPOSED OFFICE SPACE AND RETURN IS DUCTED ABOVE FALSE CEILING.

**LEGEND:**

 
- START POINT OF CEILING
- 600x600 ARMSTRONG CEILING
- 600x600 LIGHT FIXTURE
- 600x600 SUPPLY AIR DIFFUSER
- 600x600 RETURN AIR DIFFUSER
- 600x600 FRESH AIR DIFFUSER
- OCCUPANCY SENSOR
- SMOKE DETECTOR



FACILITY MAINTENANCE SERVICES  
 U.S. EMBASSY  
 NEW DELHI  
 INDIA

Drawing Title  
**PART FIRST FLOOR PLAN SHOWING PROPOSED MARINE SECURITY GUARD'S OFFICE SPACE**

**PROPOSED FALSE CEILING HVAC PLAN**



Project Title  
**PROPOSED MARINE SECURITY GUARD'S OFFICE SPACE AMERICAN CONSULATE, CHENNAI, INDIA**

Scale  
 1:100

Date  
 October 25, 2018

Drawn By-- Bidisha Biswas  
 Checked and Complied By-- Rohit Soni

DWG. NO. - A-06 (Final for Permit)

Classification  
 SENSITIVE BUT UNCLASSIFIED